


Plan View

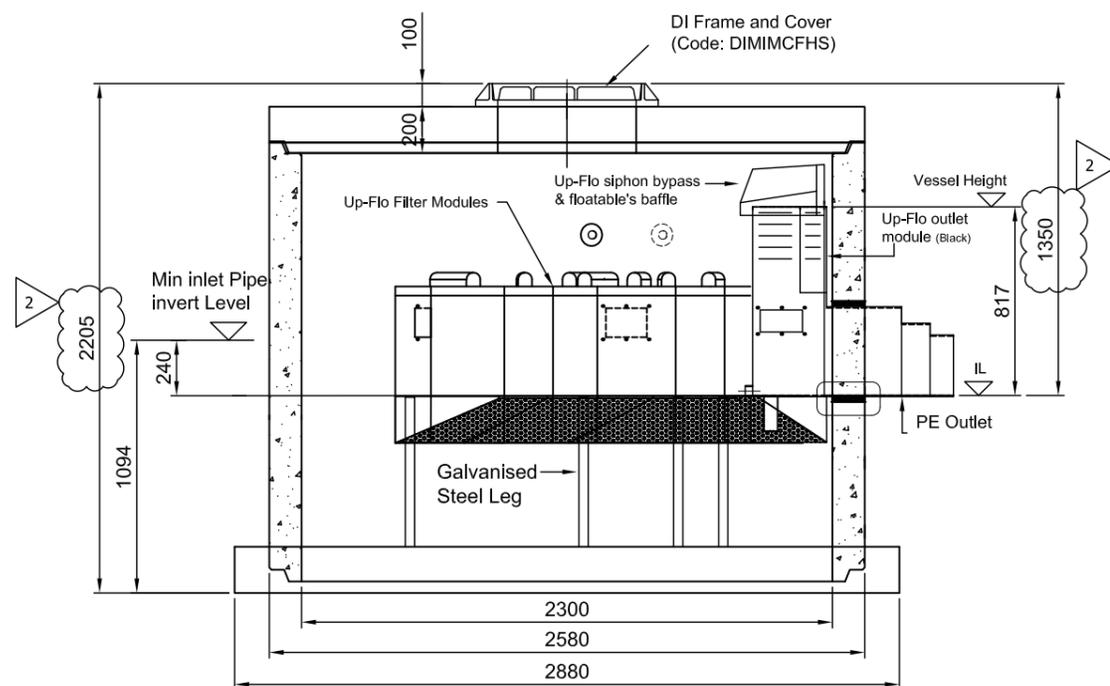

Elevation

1	DESCRIPTION - MATERIAL	CODE	UNIT WEIGHT (T)	
No Modules (✓ Tick option)	Ø2300mm FB Up-Flo Filter			
<input type="checkbox"/>	with 11 modules	UP-FLO.11C	8.693	
<input type="checkbox"/>	with 12 modules	UP-FLO.12C	8.706	
<input type="checkbox"/>	with 13 modules	UP-FLO.13C	8.719	
<input type="checkbox"/>	with 14 modules	UP-FLO.14C	8.732	
2	Lid			
	Lid 200mm Thk , Ø600mm opening- HD60	LD23200HD6HC	2.495	<input checked="" type="checkbox"/>
3	Streetware (2 x DI Covers and Frames required)			
	Ductile Iron Cover & Frame Ø600mm	DIMHMCFHS	0.058	<input checked="" type="checkbox"/>

* PLEASE TICK THE NUMBER OF MODULES YOU REQUIRE BEFORE SIGNING AND RETURNING TO HYNDS PIPES.

NOTE:

- The Up-Flo Filter can contain up to 14 modules. The invert level of optional inlet/s can be a minimum of 240mm above the invert level of the outlet pipe. Inlet pipework is installed by the contractor on site.
- The standard PE outlet pipe provides the following optional outside diameters: 389mm / 318mm / 267mm. The contractor simply trims the outlet back to the size required.
- Some dimensions could change to accommodate a site constraint situation. Please contact Hynds for technical assistance.
- The orientation and elevation of the inlet pipe can be adjusted to suit site requirements. Refer to the site plan for orientation.
- If the outlet invert depth to the ground level is >1365mm, the contractor will need to provide an appropriate riser & or Lid rings to suit the on-site requirements.
- The unit includes an Ø2300 x 1900mmH flanged based manhole chamber, 200mm thick concrete lid and a 600Ø ductile iron cover & frame is Hynds standard supply throughout NZ. Concrete lid designed to HD60 Vehicle Loads
- If the Up-Flo is installed in an offline configuration and is connecting to a weir chamber - please note that the weir panel height within the weir chamber must match the height of the UpFlo outlet "Vessel Height" as shown on drawing. Height between invert of outlet stub to Vessel Height is 817mm

I AUTHORISE HYNDS PIPES SYSTEMS LTD TO PROCEED WITH THE MANUFACTURING OF THIS PRODUCT SPECIAL AS DETAILED ABOVE.
I ACKNOWLEDGE THAT ANY SPECIALS, ONCE MANUFACTURED, ARE DEEMED TO BE MY (CUSTOMERS) PROPERTY & ARE NON REFUNDABLE. PLEASE NOTE COSTS ARISING FROM CHANGES REQUESTED AFTER SIGNING THIS DRAWING WILL BE BORNE BY THE CUSTOMER.

NAME :- SIGNATURE :-

DATE :-

NOTES:

MATERIALS

VOL (m³/unit) =
WT (ton/unit) =
CODE = UP-FLO.14CKIT

REVISIONS

REV #:	REVISION DESCRIPTION:	DATE:	DRAWN:
1	Issued For Approval	4 May 2020	GH
1	Issued For Approval	24 July 2020	GH
2	Riser Height Updated As Per T7404	23 Sept 2022	GH
----	----	----	----
----	----	----	----
----	----	----	----
----	----	----	----

PO Box 58142, Botany, Auckland, 2163
Tel: 09-274 0316
Fax: 09-272 7485
email: technicalservices@hynds.co.nz



© 2020 HYNDS PIPE SYSTEMS LTD
This drawing is the property of Hynds Pipe Systems Limited. Not to be disclosed to any other person without permission from Hynds Pipe Systems Limited. It is submitted for use only in connection with proposals and contracts of Hynds Pipe Systems Limited upon the express condition that it is not to be reproduced or copied in any form. Data to be used only with reference to products manufactured and supplied by Hynds Pipe Systems Limited.

ISO 9001 CERTIFIED MANAGEMENT SYSTEM

PROJECT DESCRIPTION:

Hynds Pipe Systems
Up-Flo 11 To 14 Module (PDEP)
Standard Drawing

SERVICE DETAIL:

Up-Flo Flanged Based Ø2300x1800
11 to 14 Modules
FB2300 x1900 (No Holes)
General Arrangement

REFERENCE/QUOTE NUMBER:

DRAWN: GH	DESIGN: GH	CHECKED: -
SIGNATURE:	SIGNATURE:	SIGNATURE:
SCALE: N.T.S	Note: Do not scale drawing if in doubt ASK!!!	DATE: 23-Sep-22
PAPER SIZE: A3		
DRAWING NUMBER: T7659 GA	SHEET NUMBER: GA of 6	REVISION NUMBER: 2